




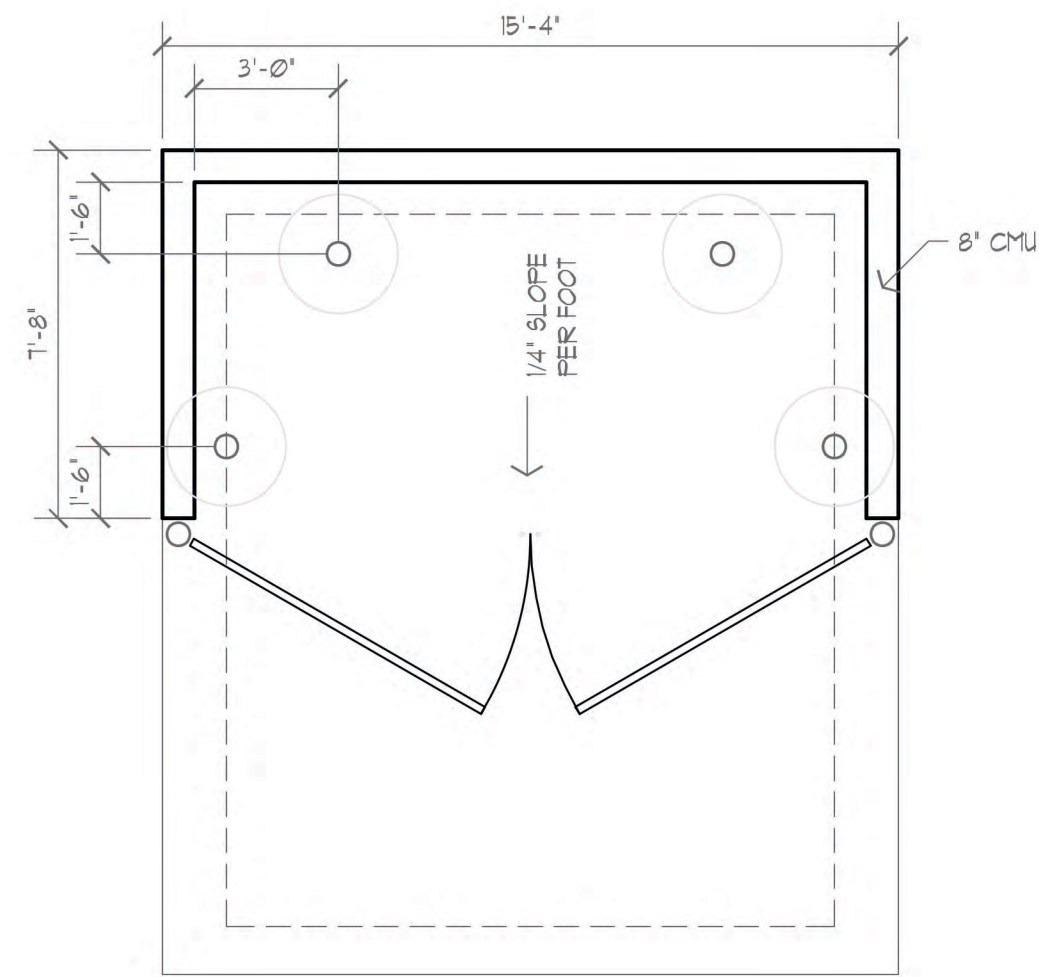


**DUMPSTER PLAN**  
SCALE: 1/4"=1'-0"

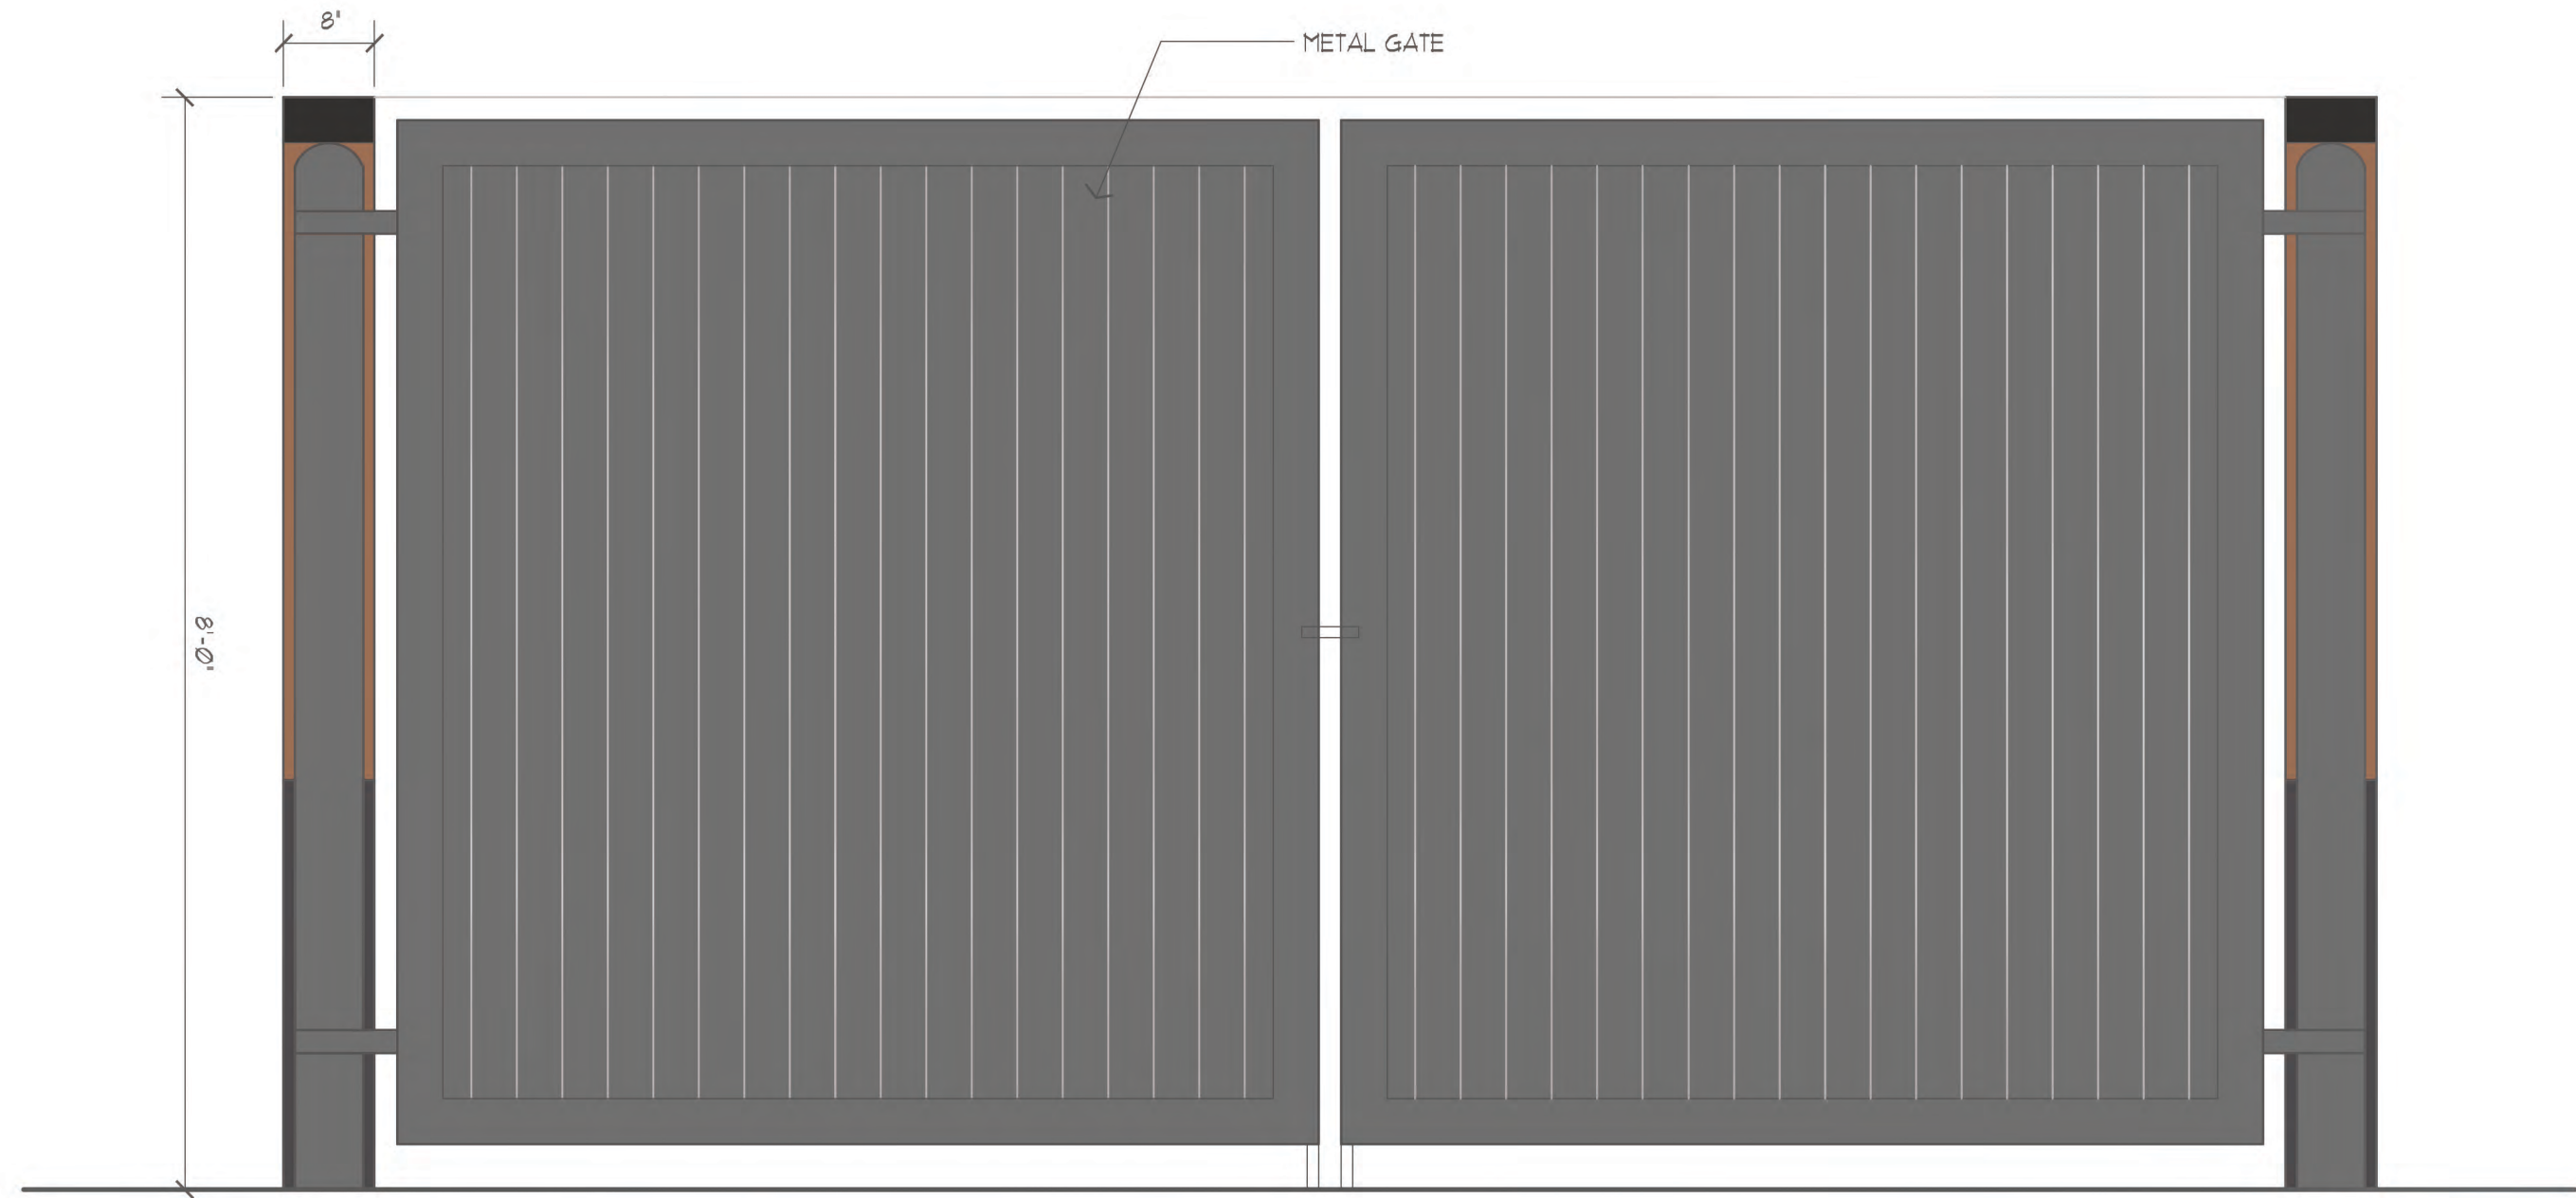

**FRONT ELEVATION**  
SCALE: 3/4"=1'-0"

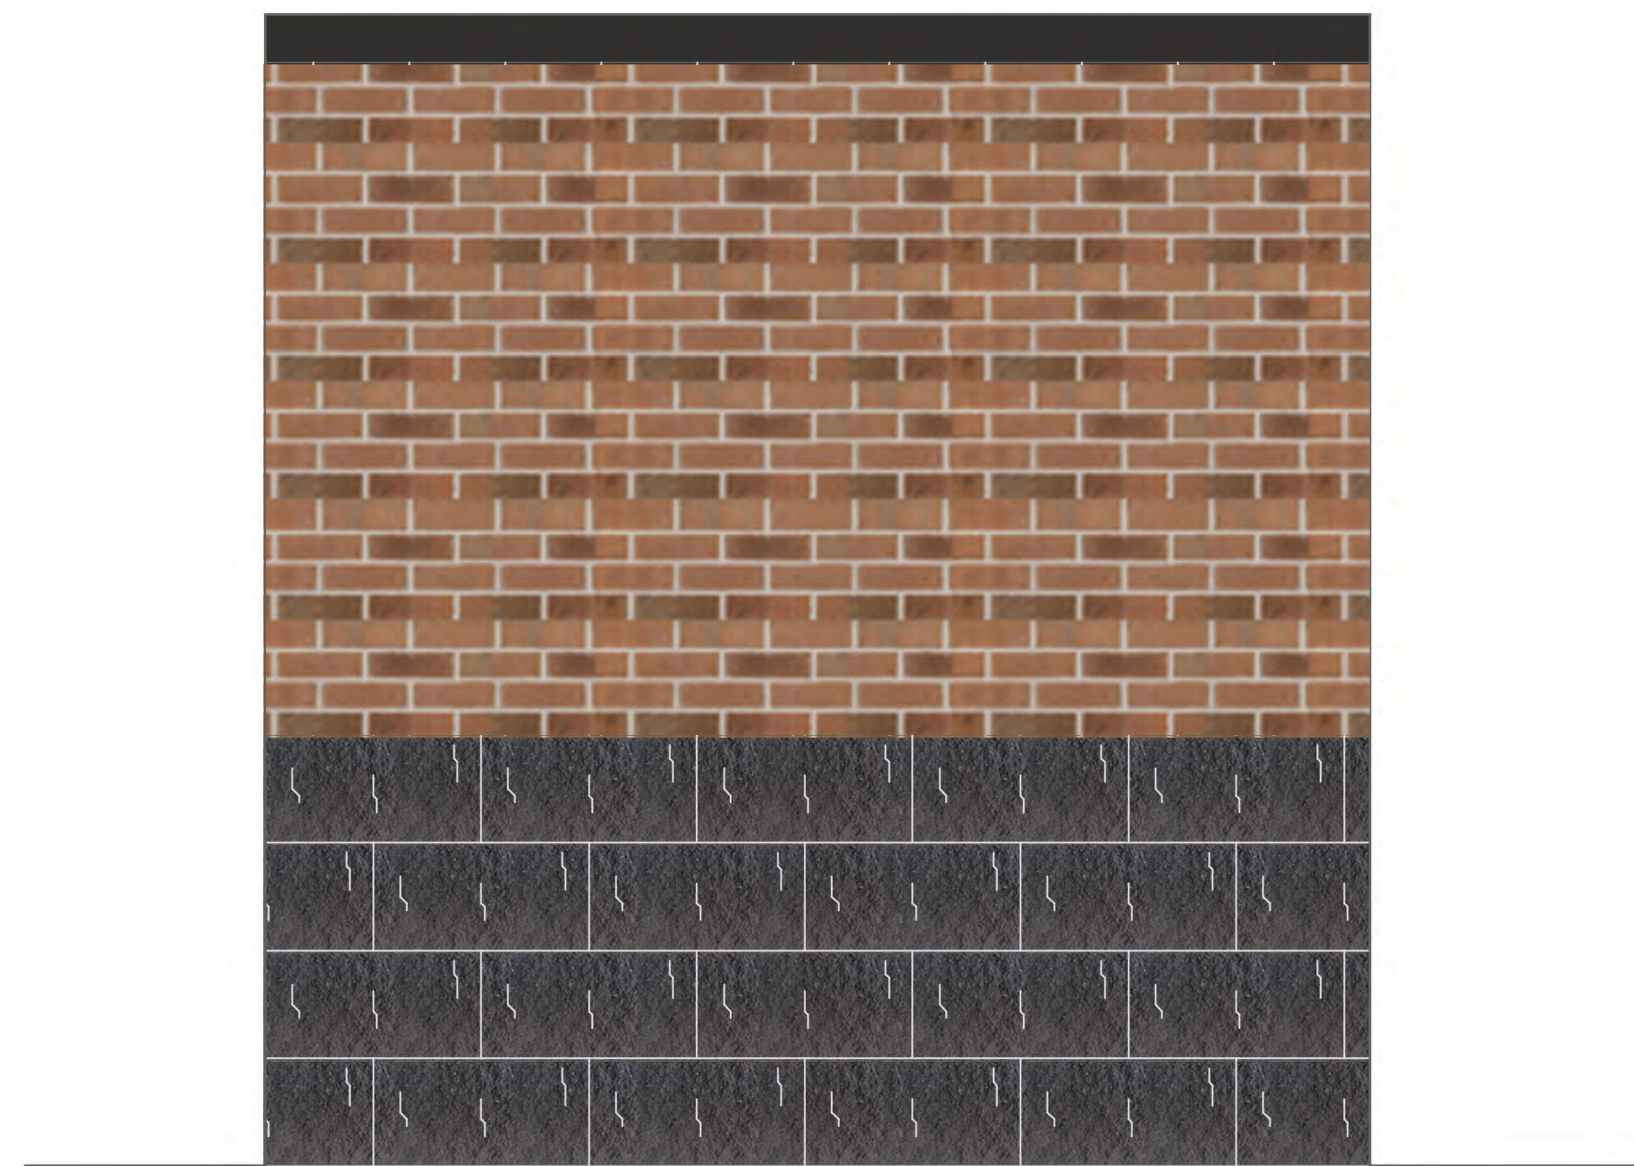

**SIDE ELEVATION**  
SCALE: 3/4"=1'-0"

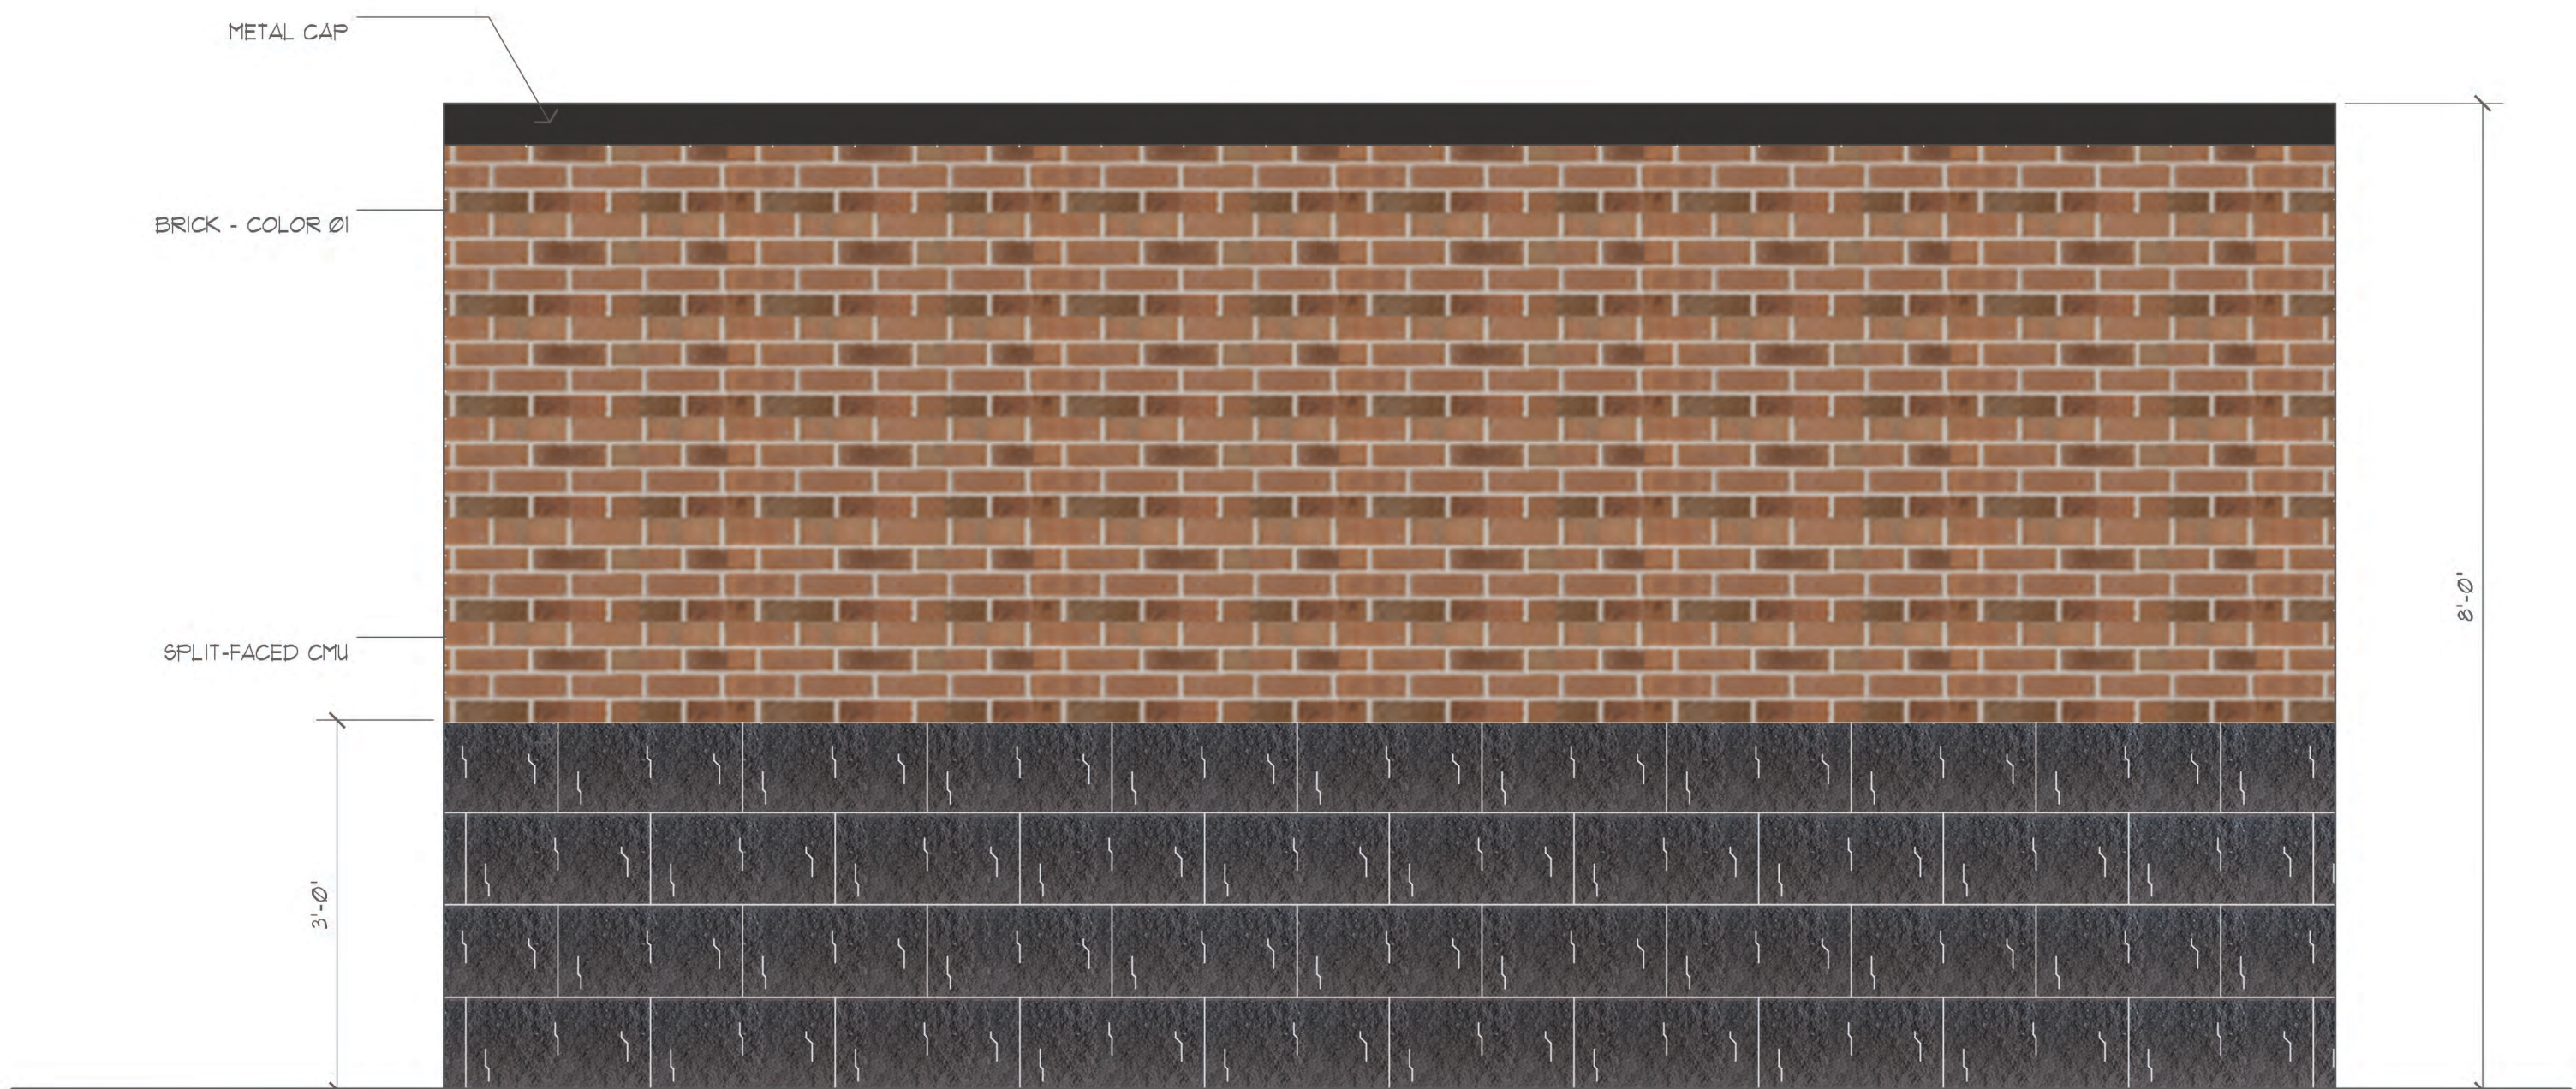

**REAR ELEVATION**  
SCALE: 3/4"=1'-0"

**peterSON**ARCHITECTURE  
298 South 10th Street Suite 500  
Noblesville, IN 46060  
p 317.770.9714  
f 317.770.9718  
peterSONarchitecture.com

**NEW CONSTRUCTION**  
**KID CITY**  
140 E MAIN STREET  
PLAINFIELD, INDIANA  
**JRF CONSTRUCTION**

PRELIMINARY DESIGN

JANUARY 2024

| REVISIONS: |          |
|------------|----------|
| 1          | REVISION |
| 2          | DATE     |
| 3          | REVISION |
| 4          | DATE     |
| 5          | REVISION |
| 6          | DATE     |

PLOT DATE: 2024-01-04  
DRAWN BY: TANKER  
CHECKED BY: -  
PROJECT NUMBER: 23-0104

DUMPSTER ENCLOSURE

**A202**

THESE DRAWINGS ARE GIVEN IN CONFIDENCE  
AND SHALL BE USED ONLY IN PURSUANT TO THE  
AGREEMENT WITH  
PETERSON ARCHITECTURE, P.C.  
NO OTHER USE OR DUPLICATION MAY BE MADE  
WITHOUT THE PRIOR WRITTEN CONSENT OF  
PETERSON ARCHITECTURE, P.C.  
ALL OTHER COPYRIGHT AND COMMON LAW  
RIGHTS ARE HEREBY SPECIFICALLY RESERVED.