

	Source Four PAR MFL
	Source Four PAR WFL
	Source Four 50°
	Source Four 36°
	Source Four 26°
	Source Four 19°
	Source Four 14°
	PAR64 VNSP
	PAR64 MFL
	PAR64 MFL
	ETC Source4 Fresnel
	MR-16 Birdie
	PRACTICAL
	Hanging Practical
	300w Flood Light
	150w Flood Light
	MAC Encore Perf. CLD
	High End Systems Studio Color 575
	6x9
	6x12
	6x16
	ETC Source 4 Lustr II 26 deg
	AltmanSpectra Cyc 100
	ADJ Flat Par TR17XS
	AX3
	T-3 Strip Light
	R40 Strip Light
	L&E Ministrip

A diagram of the front of a projector. It shows a central lens area with a 'G' logo. Above the lens is a 'PURPOSE COLOR' label. Below the lens is a 'UNIT NUMBER' label. To the right of the lens is a 'GOBO' label. Below the lens is a 'CHANNEL' label.

- PLEASE HAVE R132+R119 AVAILABLE AT FOCUS
- CONSULT DESIGNER WITH ANY CHANGES

FESTIVAL STAGE
ALABAMA SHAKESPEARE FESTIVAL

HS

AFF	DESIGNER	J. BEHN
	DIRECTOR	R. DILDINE
	MASTER ELECTRICIAN	P. HAHN

01. PRELIM 5-19-23
02. PRELIM UPDATE 5-21
03. RE-CHANNEL 6-1
04. LADDER 1 CUT 6-6


DRAWN BY: JPB	SCALE: 1/2"=1'-0"
-------------------------	-----------------------------


CON

01

PUBLISH DATE:
6/6/2023

LX STAGE

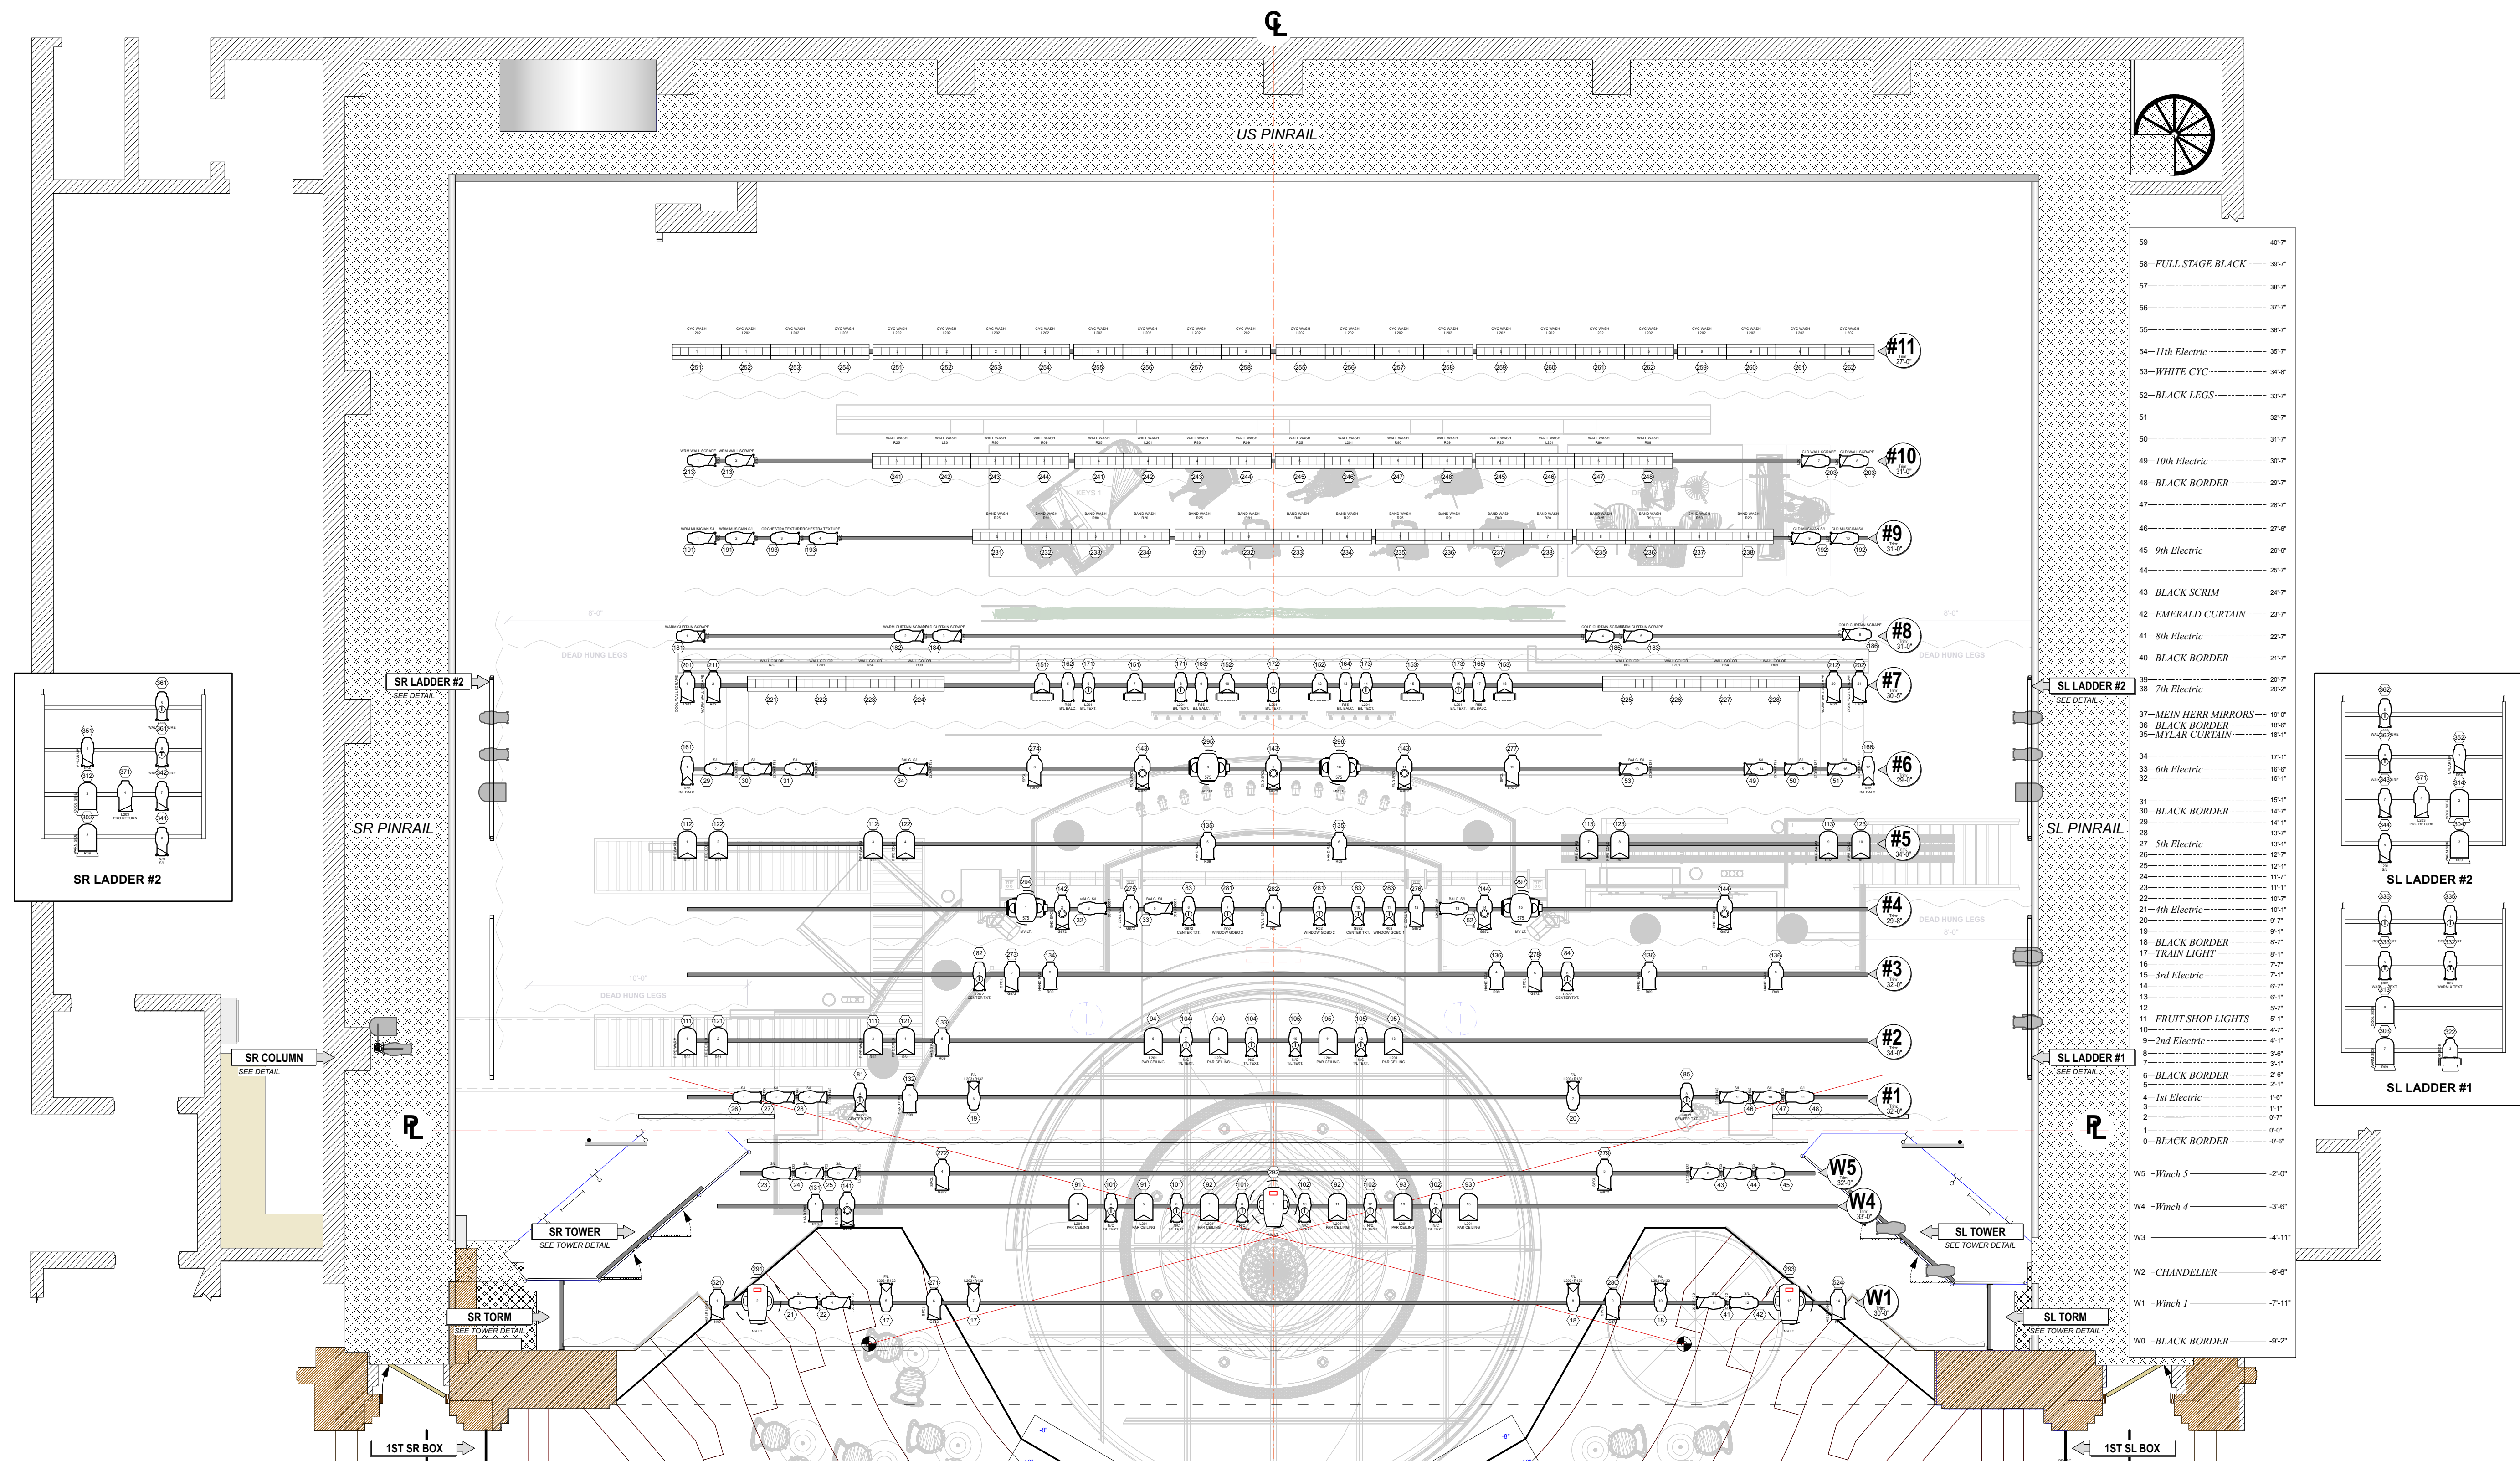

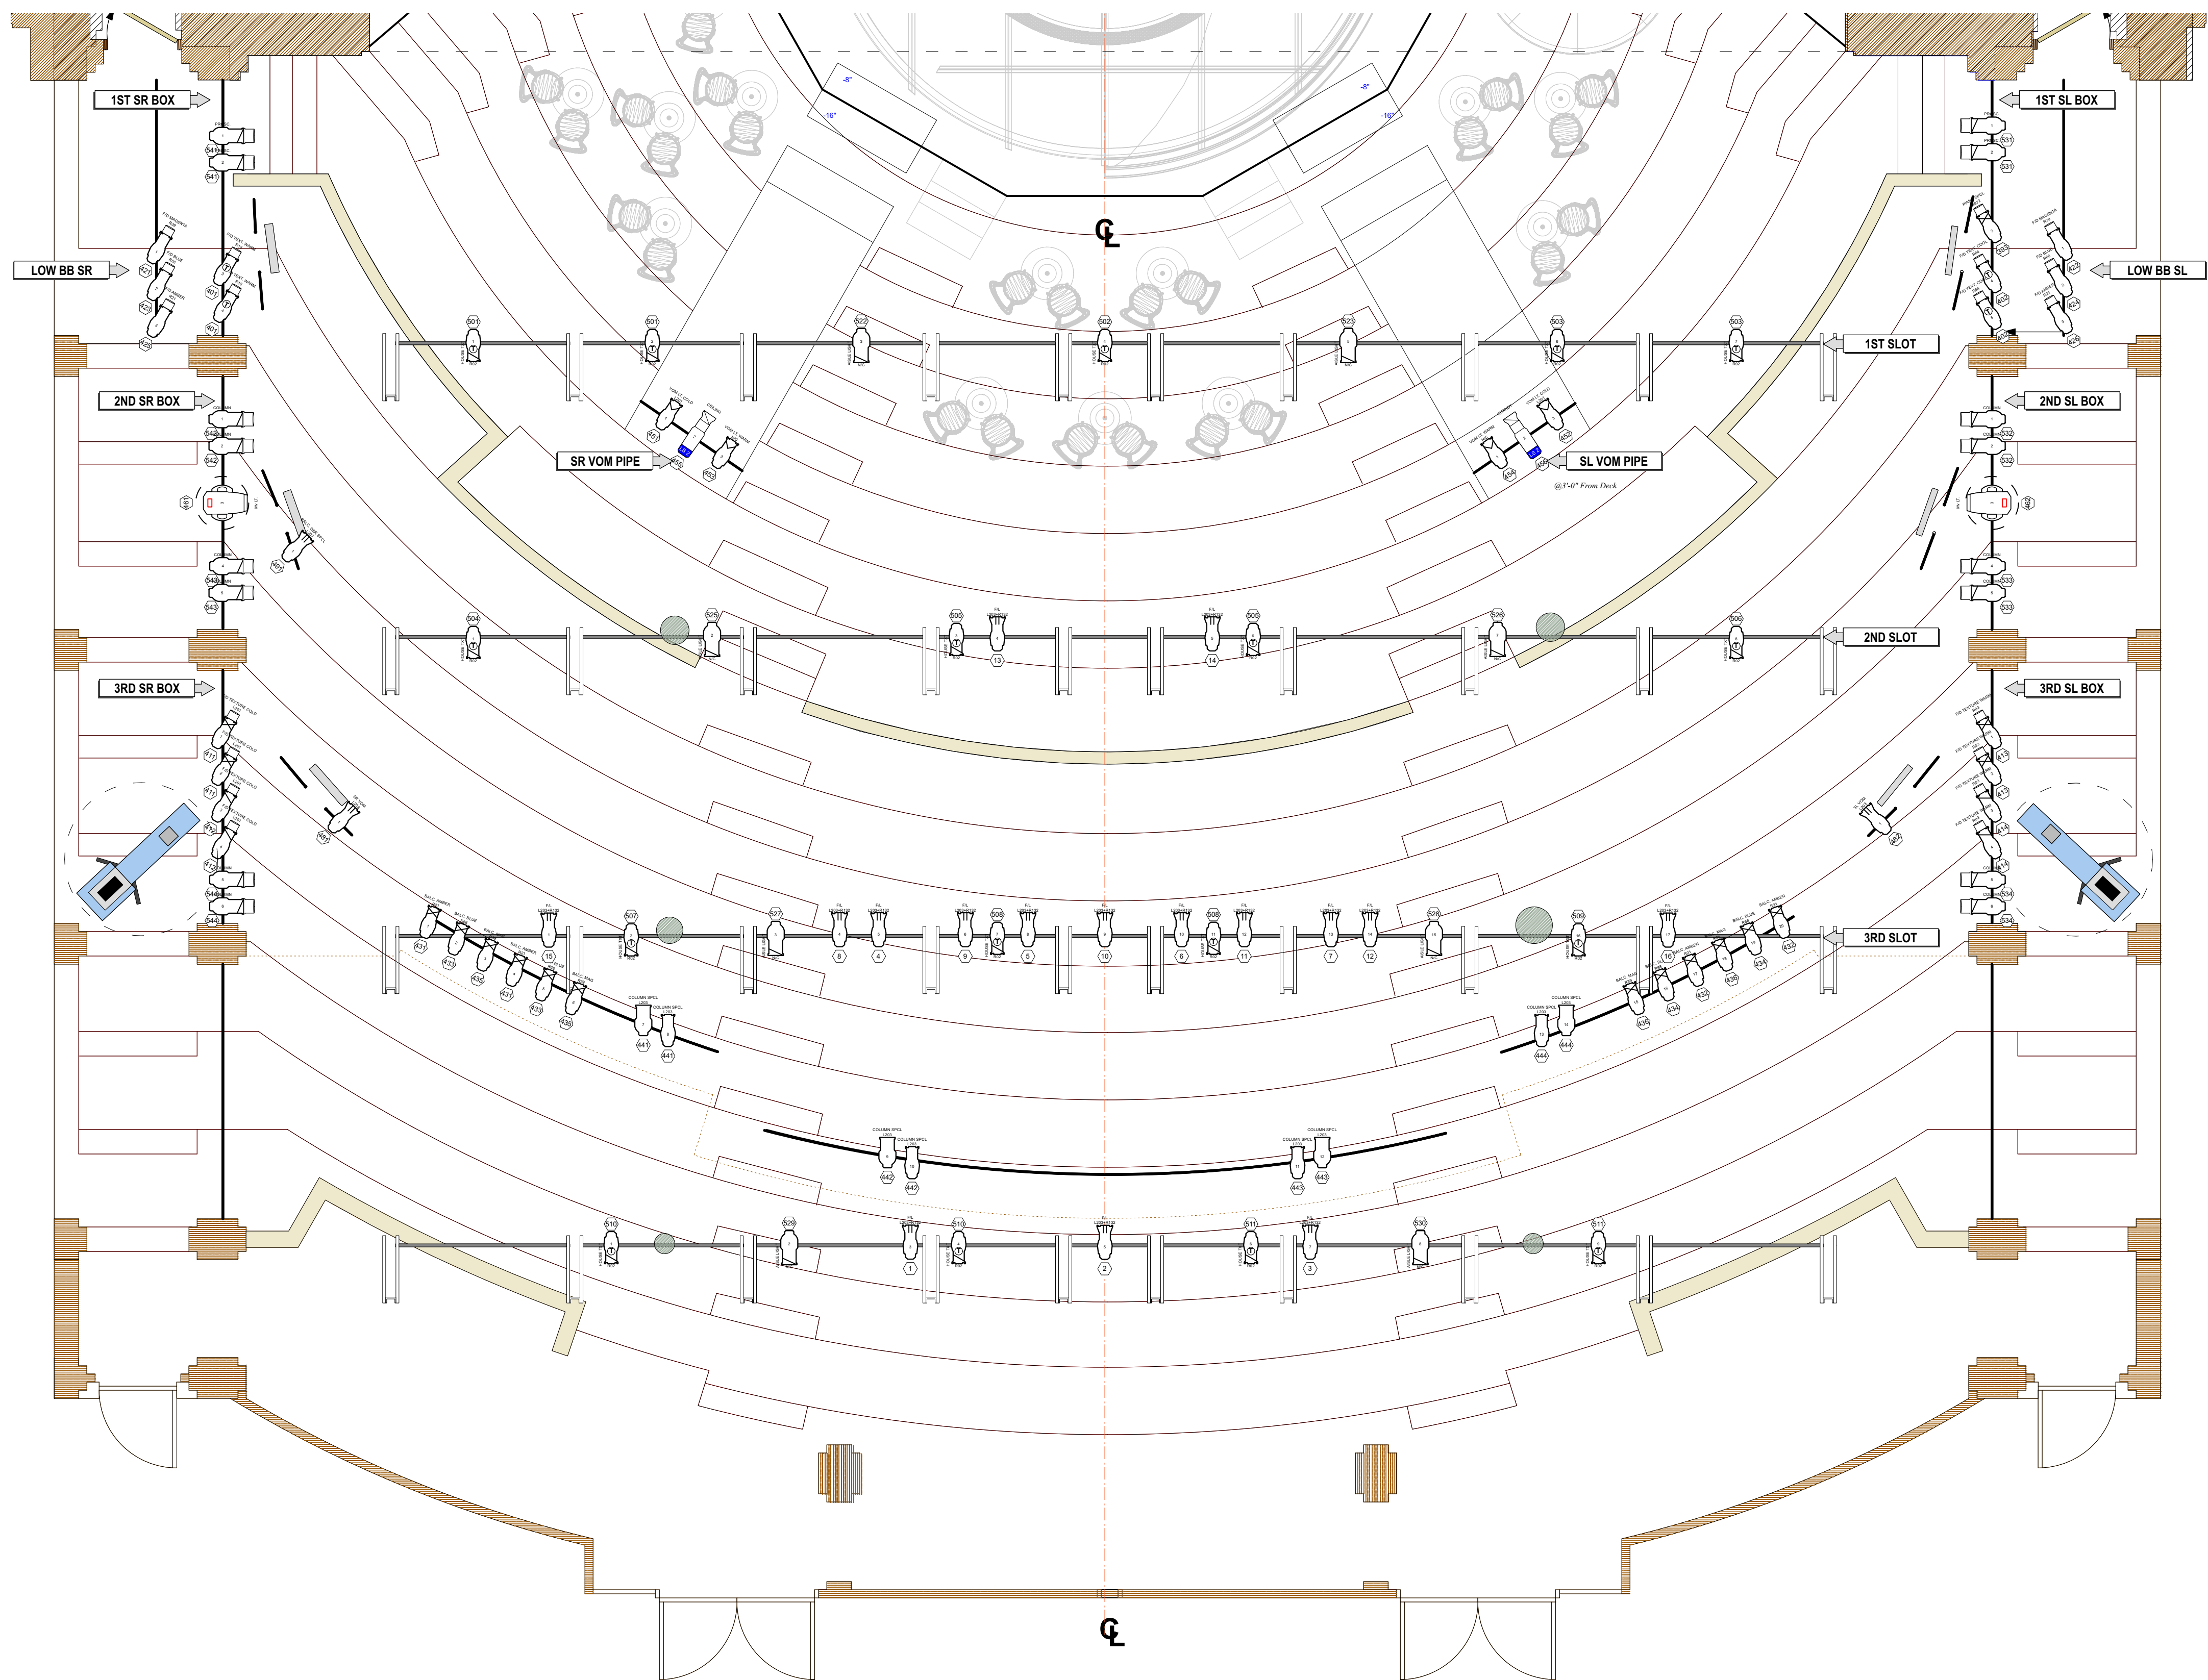

PLAY GLORIA

PRODUCTIONS

JEFF BEHM

(314) 458-9638

jbehmdesign@gmail.com

This document and the ideas and design incorporated herein, as an instrument of professional service, is the property of PGP and is not to be used, in whole or part, for any other project without the written authorization of PGP. This document is not to be reproduced and/or modified in any way, our work or reproduction of this document be modified, with our prior written consent of PGP. This drawing represents visual concepts and construction suggestions only. It does not replace the knowledge and advice of a licensed structural engineer. The designer does not warrant, in any way, the accuracy of the information and shall not be responsible for discrepancies between this document and the existing conditions. The designer will not assume responsibility for improper engineering, construction, handling or use of this lighting equipment.

INSTRUMENT KEY

Source Four PAR MFL

Source Four PAR WFL

Source Four 50°

Source Four 36°

Source Four 26°

Source Four 19°

Source Four 14°

PAR64 VNSP

PAR64 WFL

PAR64 MFL

ETC Source4 Fresnel

MR-16 Birdie

PRACTICAL

Hanging Practical

300w Flood Light

150w Flood Light

MAC Encore Perf. CLD

High End Systems Studio Color 575

6x9

6x12

6x16

ETC Source 4 Lustr II 26 deg

AltmanSpectra Cyc 100

ADJ Flat Par TRI7XS

AX3

T-3 Strip Light

R40 Strip Light

L&E Ministrip

LEGEND

PURPOSE

COLOR

UNIT NUMBER

CHANNEL

GOGO

NOTES

PLEASE HAVE R12D-R17D AVAILABLE AT FOCUS

CONSULT DESIGNER WITH ANY CHANGES

VENUE

FESTIVAL STAGE

ALABAMA SHAKESPEARE FESTIVAL

SHOW

CABARET

LOAD-IN

SHOWDAY

SHOW #

?

7/7/23

#0002

DESIGNER

DIRECTOR

MASTER ELECTRICIAN

J. BEHM

R. DILDINE

P. HAHN

VERSION

STAFF

01. PRELIM 5-19-23

02. PRELIM UPDATE 5-21

03. RE-CHANNEL 6-1

04. LADDER 1 CUT 6-6

0"

1"

2"

PRINT ARCH D SHEET

DRAWN BY:

SCALE:

JPB

1/2"=1'-0"

CONTENTS

01. LX STAGE

02. LX FOH

03. LX DETAIL

04. LX FLOOR

05. LX SECTION

SHEET #

02

PUBLISH DATE:

6/6/2023

LX FOH

PLAY GLORIA PRODUCTIONS

JEFF BEHM

(314) 458-9638

jbehmdesign@gmail.com

This document and the ideas and design incorporated herein, as an instrument of professional service, is the property of PGP and is not to be used, in whole or in part, for any other project without the written authorization of PGP. This document is not to be reproduced and/or modified in any way, our shall any reproduction of this document be modified, with out our written consent of PGP. This drawing represents visual concepts and construction suggestions only. It does not replace the knowledge and advice of a licensed structural engineer. The designer does not warrant, in any way, the accuracy of the information and shall not be responsible for discrepancies between this document and the existing conditions. The designer will not assume responsibility for improper engineering, construction, handling or use of this lighting equipment.

INSTRUMENT KEY

Source Four PAR MFL

Source Four PAR WFL

Source Four 50°

Source Four 36°

Source Four 26°

Source Four 19°

Source Four 14°

PAR64 VNSP

PAR64 WFL

PAR64 MFL

ETC Source4 Fresnel

MR-16 Birdie

PRACTICAL

Hanging Practical

300w Flood Light

150w Flood Light

MAC Encore Perf. CLD

High End Systems

Studio Color 575

6x9

6x12

6x16

ETC Source 4 Lustr II

26 deg

AltmanSpectra Cyc 100

ADJ Flat Par TRI7XS

AX3

T-3 Strip Light

R40 Strip Light

L&E Ministrip

LEGEND

PURPOSE

COLOR

UNIT NUMBER

CHANNEL

NOTES

PLEASE HAVE RTD-RY119 AVAILABLE AT FOCUS

CONSULT DESIGNER WITH ANY CHANGES

VENUE

FESTIVAL STAGE

ALABAMA SHAKESPEARE FESTIVAL

SHOW

CABARET

LOAD-IN

SHOWDAY

SHOW #

?

7/7/23

#0002

DESIGNER

DIRECTOR

MASTER ELECTRICIAN

J. BEHM

R. DILDINE

P. HAHN

VERSION

STAFF

01. PRELIM 5-19-23

02. PRELIM UPDATE 5-21

03. RE-CHANNEL 6-1

04. LADDER 1 CUT 6-6

0"

1"

2"

PRINT ARCH D SHEET

DRAWN BY:

JPB

SCALE:

1/2"=1'-0"

CONTENTS

01. LX STAGE

02. LX FOH

03. LX DETAIL

04. LX FLOOR

05. LX SECTION

SHEET #

03

PUBLISH DATE:

6/6/2023

LX DETAILS

29' - 2 1/4"

29' - 10 3/4"

24' - 11"

21' - 2 1/2"

18' - 11"

16' - 11"

12' - 8 1/2"

10' - 5 1/2"

DISK LEVEL

SR Pro Position

SR Tower Position

SR Tower-Pipe Position
(See Plan View)

SR Tower-Pipe Position
(See Plan View)

SR Tower Position

SR Pro Position

2' - 2"

1' - 11"

2' - 1"

2' - 2"

5' - 9"

2' - 4"

2' - 6"

3' - 7"

8' - 3"

7' - 11 3/4"

7' - 11 1/2"

13' - 9 1/2"

16' - 4"

1' - 10 1/2"

1' - 10"

1' - 11"

2' - 1"

2' - 2"

SOURCE FOURS ON SIDE
ARM YOKED TOWARD
STAGE; SEE PLAN

29' - 2 1/4"

29' - 10 3/4"

24' - 11"

21' - 2 1/2"

18' - 11"

16' - 11"

12' - 8 1/2"

10' - 5 1/2"

DISK LEVEL

SL Tower-Pipe Position
(See Plan View)

SL Tower Position

SL Pro Position

8' - 3"

6' - 1"

2' - 4"

5' - 9"

1' - 11"

2' - 1"

2' - 2"

Front Elevation (Stage Right)

Stage Right Column

Front Elevation (Stage Left)

ASF Festival Theater
SR Tower, Tower-Pipe, and Torm Detail
(SL Tower, Tower-Pipe, and Torm Mirror This Side)

ASF Festival Theater
SL Tower, Tower-Pipe, and Torm Detail
(SL Tower, Tower-Pipe, and Torm Mirror This Side)

1

SR & SL TOWER DETAIL

Scale: 1/4" = 1'-0"



INSTRUMENT KEY

Source Four PAR MFL

- ### LEGEND

	PURPOSE	COLOR
1	1	1

- ## NOTES

- PLEASE HAVE R132+R119 AVAILABLE AT FOCUS
- CONSULT DESIGNER WITH ANY CHANGES

- #### VENUE

FESTIVAL STAGE
ALABAMA SHAKESPEARE FESTIVAL

--	--

CABARET

SHS

DESIGNER	J. BEHM
DIRECTOR	R. BEHM

TRA

02. PRELIM UPDATE 5-21
03. RE-CHANNEL 6-1

V


DRAWN BY: JPB	SCALE: 1/2"=1'-0"
-------------------------	-----------------------------


03. LX DETAIL
04. LX FLOOR
05. LX SECTIONSHEET #

04

6/6/2023

LA FLOOR

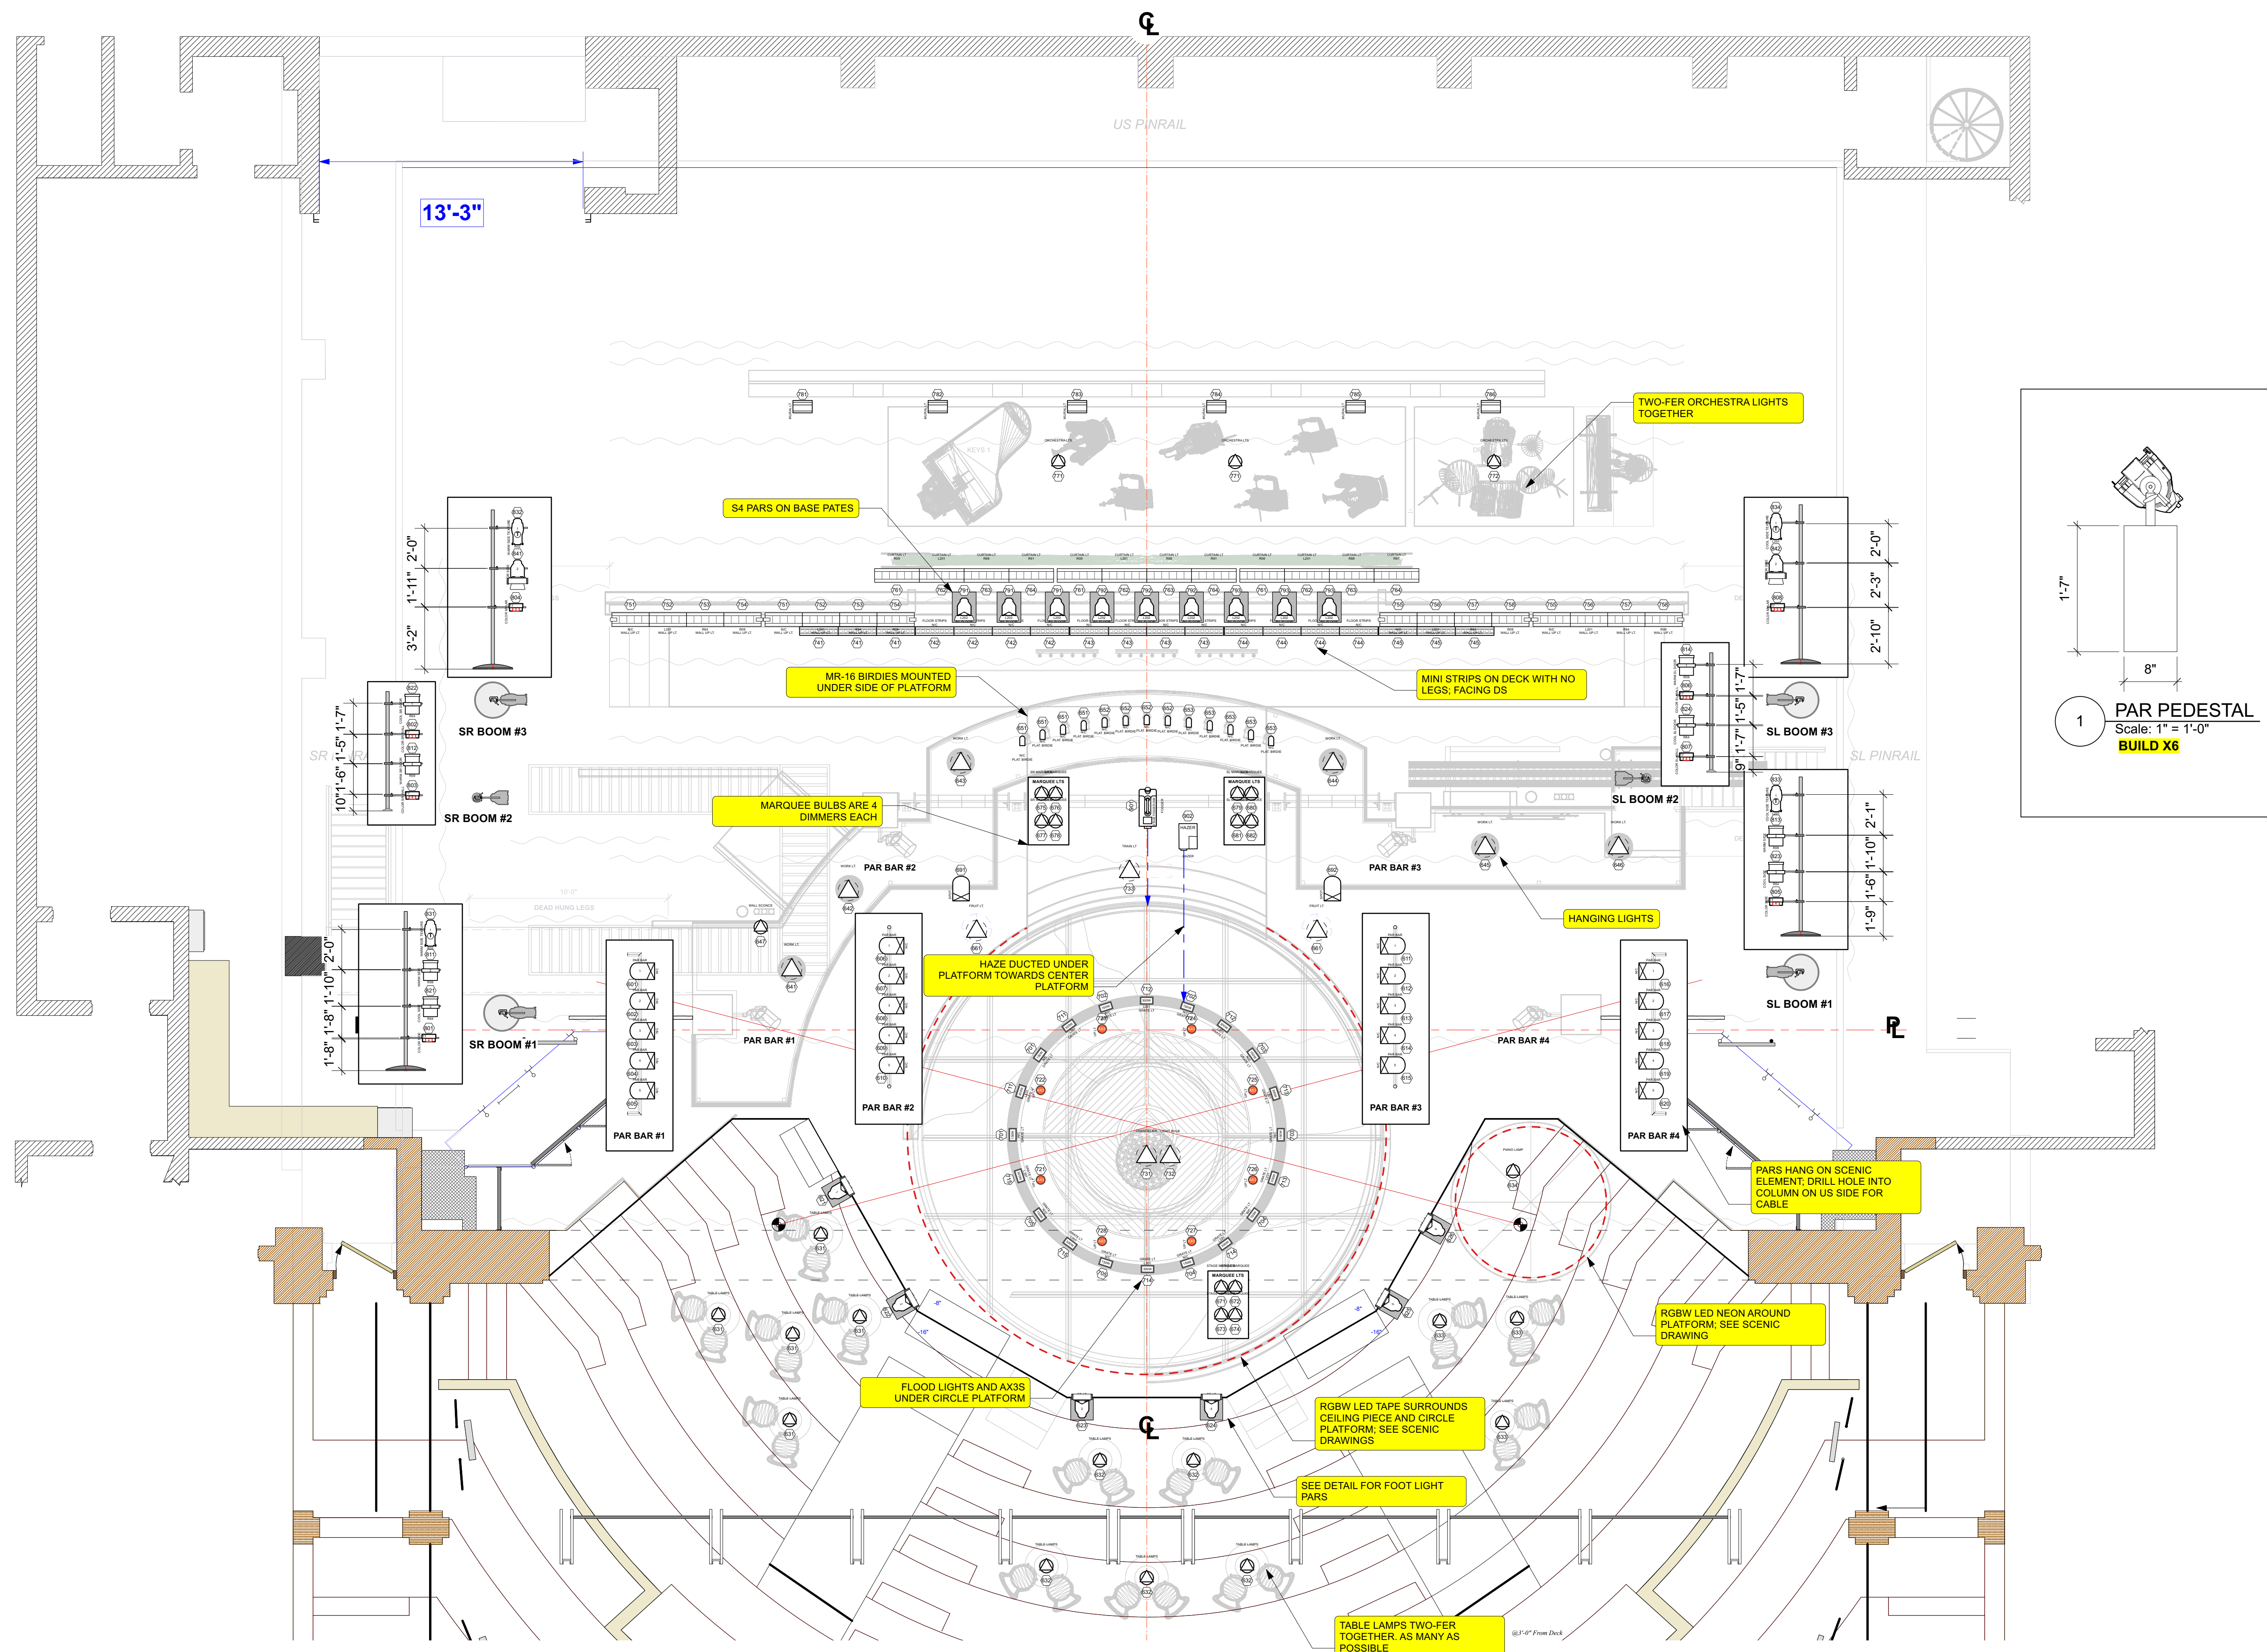

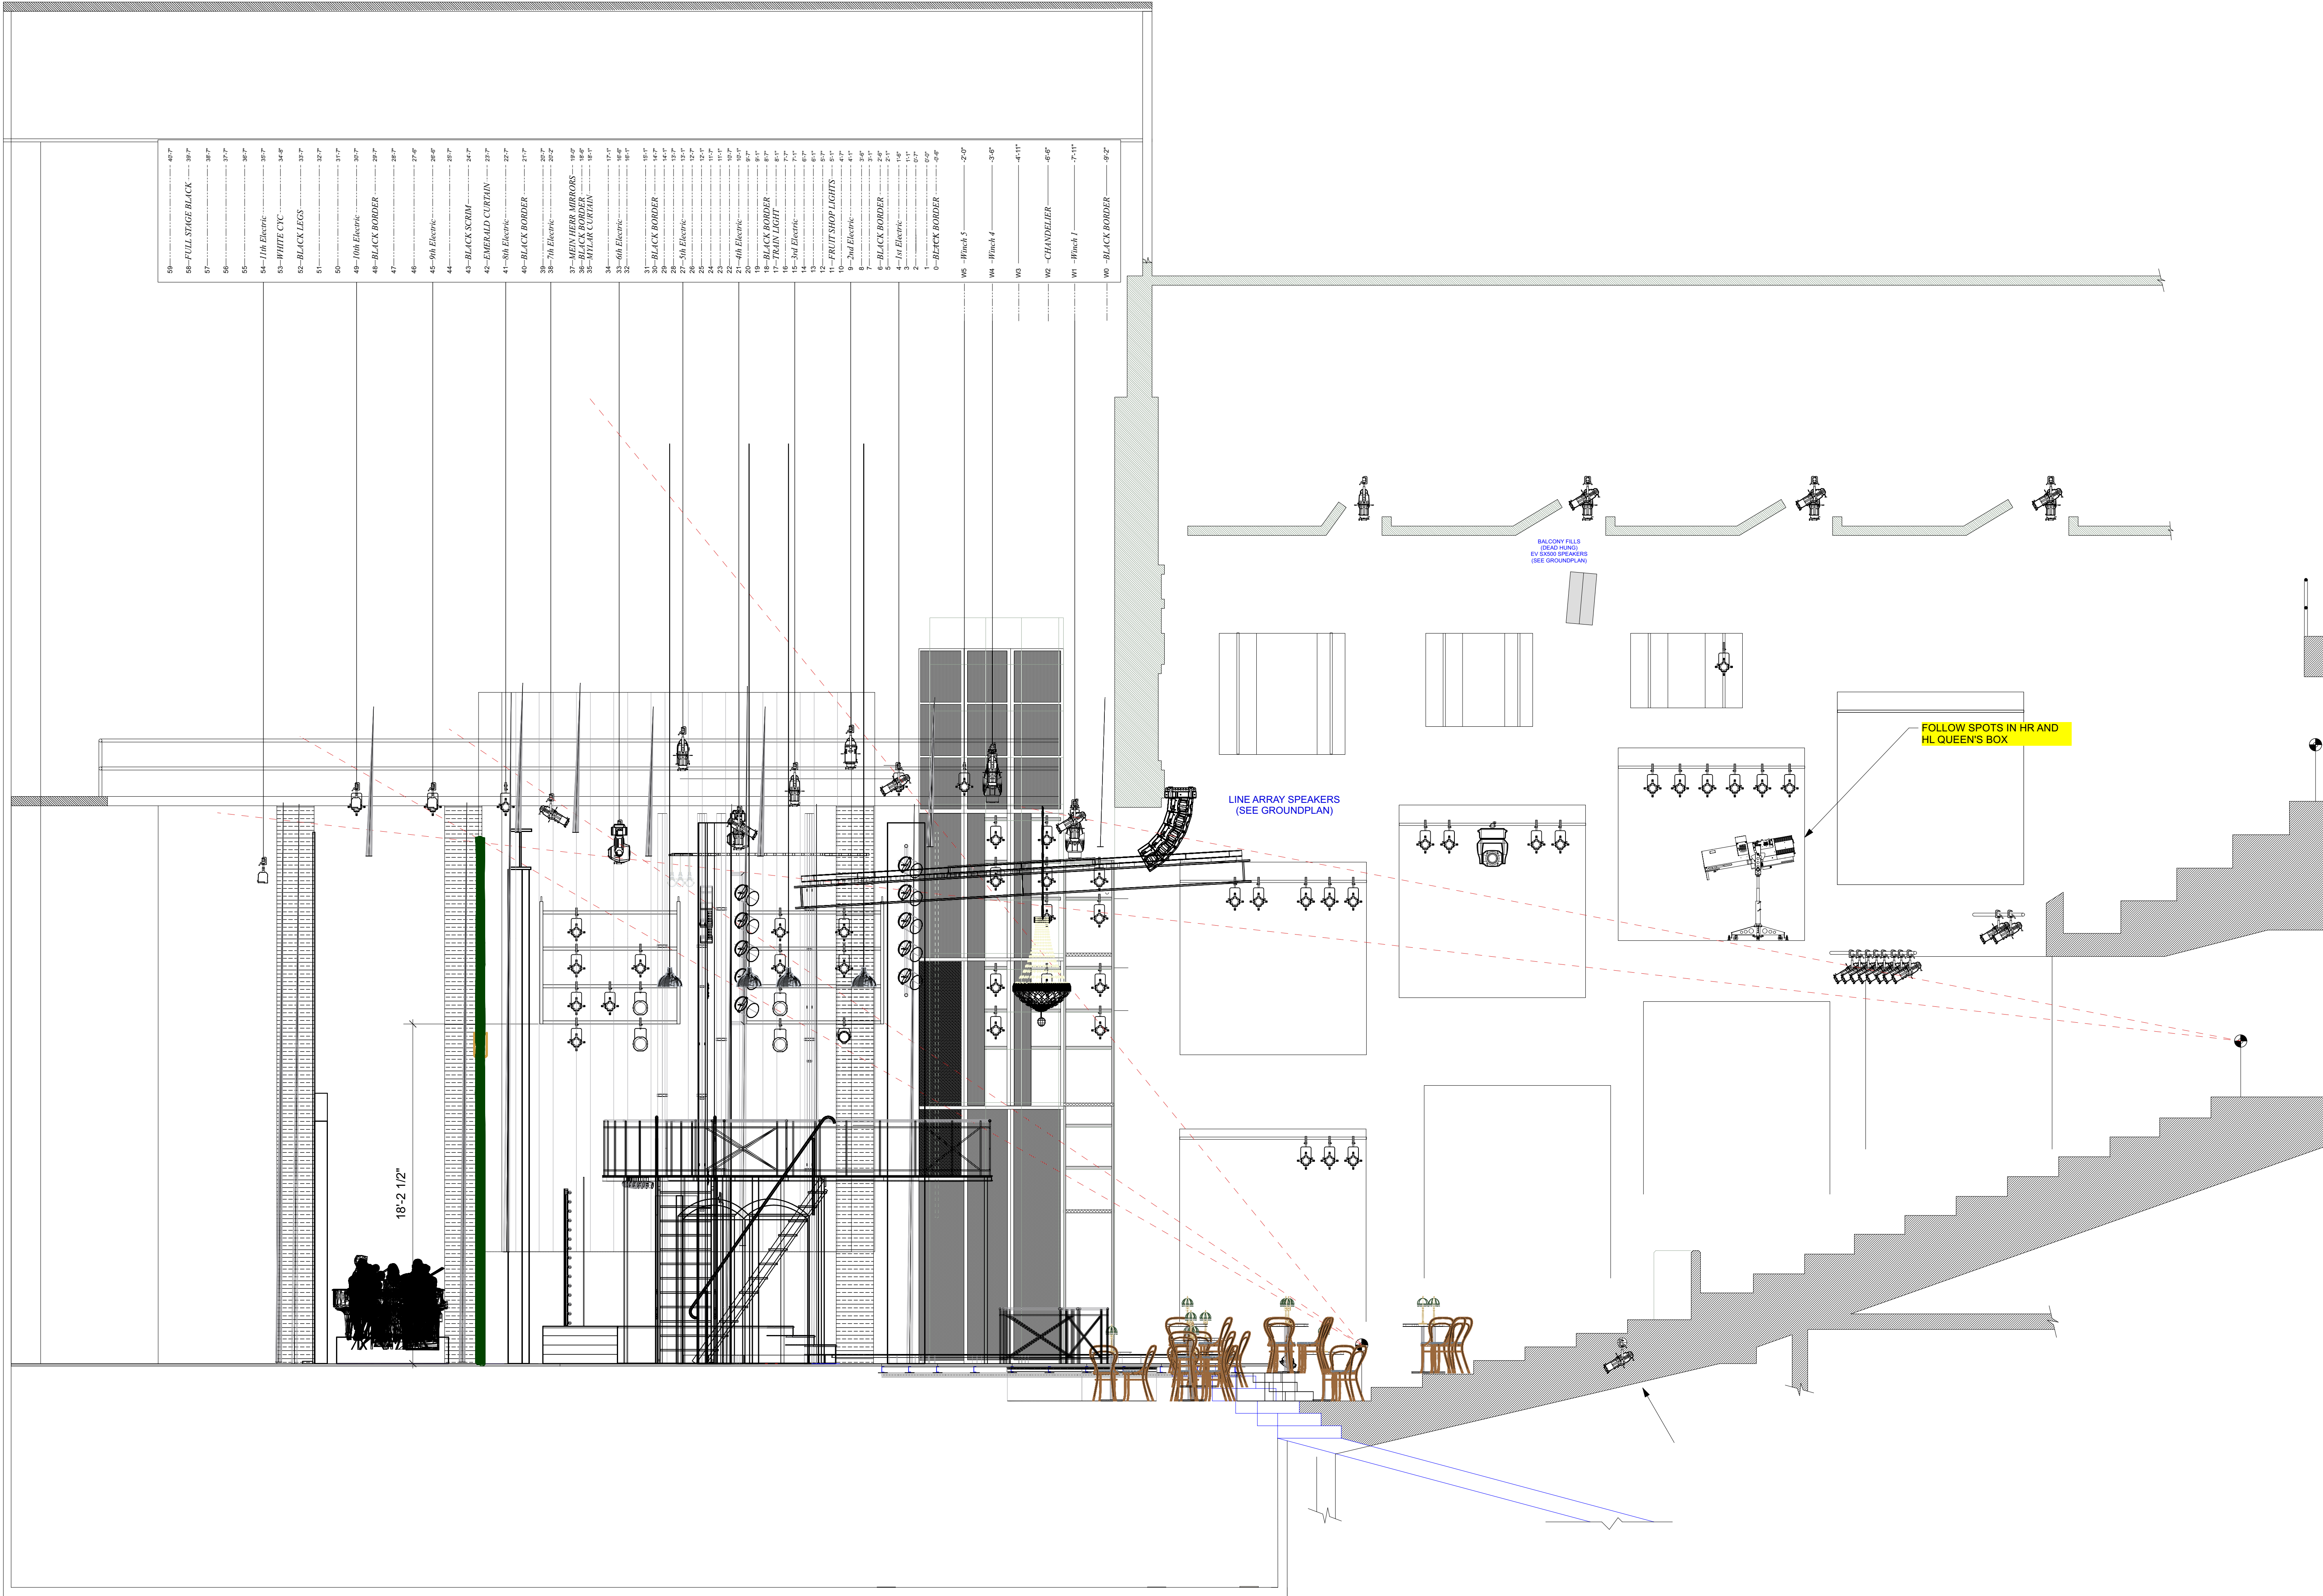

PLAY GLORIA

PRODUCTIONS

JEFF BEHM

(314) 458-9638

jbehmdesign@gmail.com

This document and the ideas and design incorporated herein, as an instrument of professional service, is the property of PGP and is not to be used, in whole or part, for any other project without the written authorization of PGP. This document is not to be reproduced or modified in any way, nor shall any reproduction of this document be modified, with out prior written consent of PGP. This drawing represents visual concepts and construction suggestions only. It does not replace the knowledge and advice of a licensed structural engineer. The designer does not warrant, in any way, the accuracy of this information and shall not be responsible for discrepancies between this document and the existing conditions. The designer will not assume responsibility for improper engineering, construction, handling or use of this lighting equipment.

INSTRUMENT KEY

Source Four PAR MFL

Source Four PAR WFL

Source Four 50"

Source Four 36"

Source Four 26"

Source Four 19"

Source Four 14"

PAR64 VNSP

PAR64 WFL

PAR64 MFL

ETC Source4 Fresnel

MR-16 Birdie

PRACTICAL

Hanging Practical

300w Flood Light

150w Flood Light

MAC Encore Perf. CLD

High End Systems

Studio Color 575

6x9

6x12

6x16

ETC Source 4 Lustr II

26 deg

AltmanSpectra Cyc 100

ADJ Flat Par TRI7XS

AX3

T-3 Strip Light

R40 Strip Light

L&E Ministrip

LEGEND

PURPOSE

COLOR

UNIT NUMBER

GOGO

CHANNEL

CHANNEL

NOTES

PLEASE HAVE R12-DH119 AVAILABLE AT FOCUS

CONSULT DESIGNER WITH ANY CHANGES

VENUE

FESTIVAL STAGE

ALABAMA SHAKESPEARE FESTIVAL

SHOW

CABARET

LOAD-IN

SHOWDAY

SHOW #

?

7/7/23

#0002

DESIGNER

DIRECTOR

MASTER ELECTRICIAN

J. BEHM

R. DILDINE

P. HAHN

VERSION

STAFF

01. PRELIM 5-19-23

02. PRELIM UPDATE 5-21

03. RE-CHANNEL 6-1

04. LADDER 1 CUT 6-6

0"

1"

2"

PRINT ARCH D SHEET

DRAWN BY:

SCALE:

JPB

1/2"=1'-0"

CONTENTS

01. LX STAGE

02. LX FOH

03. LX DETAIL

04. LX FLOOR

05. LX SECTION

SHEET #

05

PUBLISH DATE:

6/6/2023

LX SECTION